


BASEMENT


NOTES:




4 HERMITAGE CLOSE THREE LEGGED CROSS WIMBORNE DORSET BH21 6QA Tel: 07835 742300 Email: autocad_drawings@btinternet.c

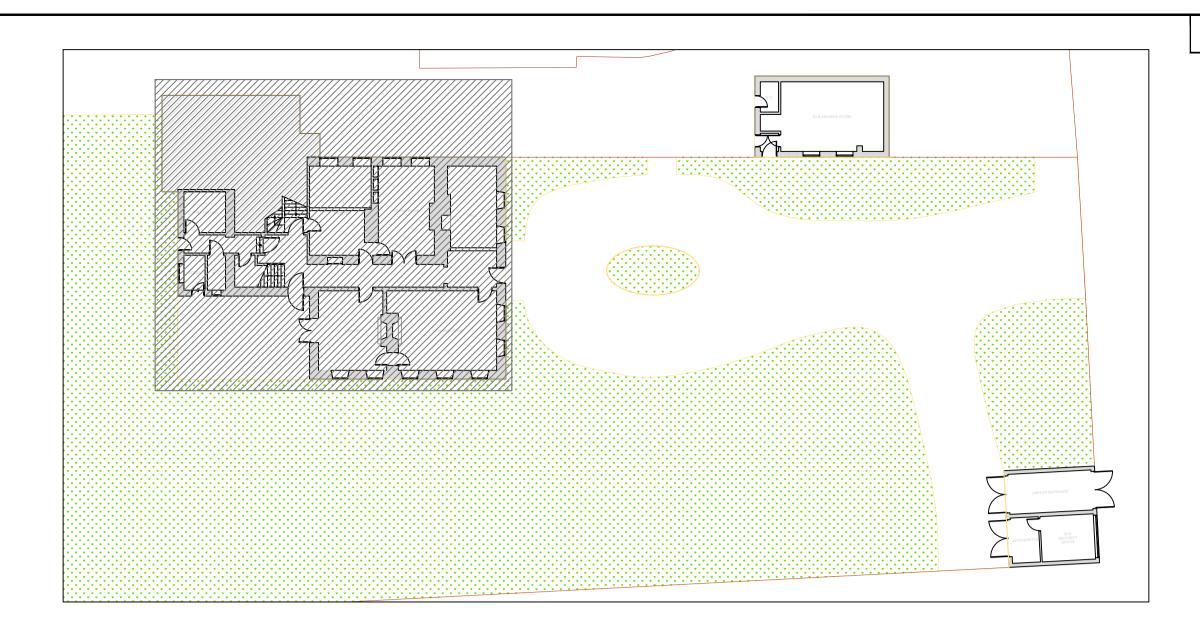

SITE PLAN - SCALE 1:250

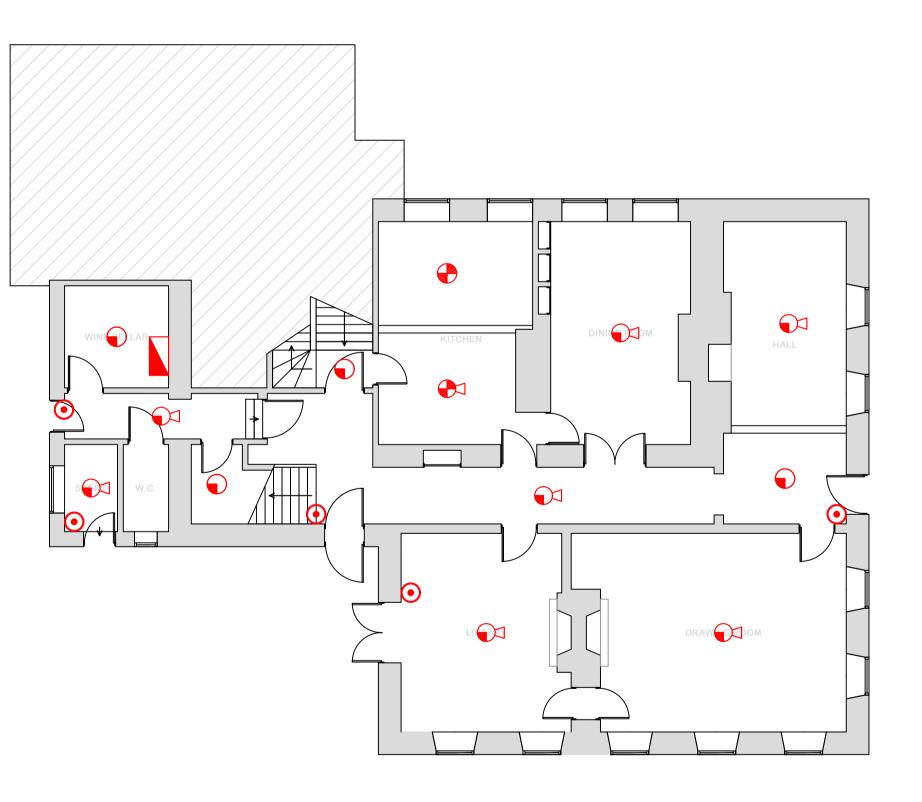

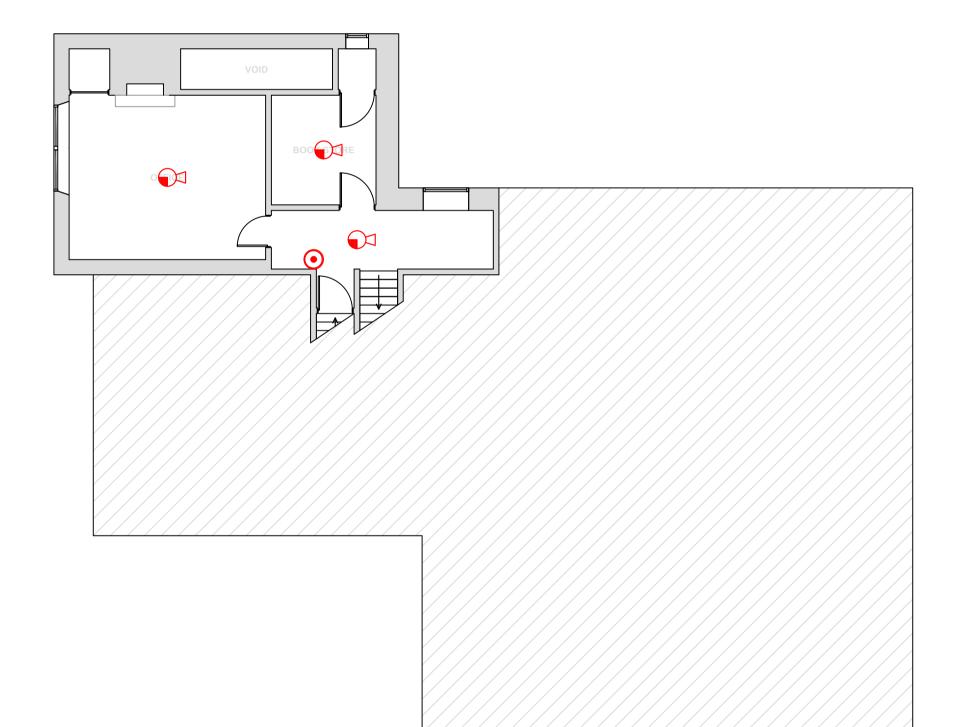


GROUND FLOOR


					Project:	Title:
t.com					Arundells 59 The Close Salisbury Wiltshire SP1 2ER	Proposed Fire Alarm System Replacement / Upgrade MAIN HOUSE - LOWER FLOORS
	Revision	Description	Date	Checked		
		AMENDMENT RECORD				

	ALL DIMENSIONS ARE IN MILLIMETRES UNLESS OTHERWISE STATED DO NOT SCALE FROM THIS DRAWING								
Fire A	larm								
ullet	CALLPOINT								
\mathbf{O}	SMOKE DETECTOR								
	HEAT DETECTOR								
$\mathbf{O}^{\mathbf{I}}$	COMBINED SMOKE DETECTOR/SOUNDER								
	COMBINED HEAT DETECTOR/SOUNDER								
	ELECTRONIC SOUNDER								
RIM	RELAY INTERFACE MODULE								
	MAIN FIRE CONTROL PANEL								
R	FIRE RADIO CLUSTER COMMUNICATOR (RCC)							
	ELECTRICAL DISTRIBUTION BOARD/SUPPLY								

LOWER FIRST FLOOR

Drawn By: ISW	Date: MAY 15	© This drawing and/or design is the property of 'LIFE SAFETY SYSTEMS' and shall not be reproduced or copied in the whole or part in any way or conveyed to a third party without the owners written permission.							
Checked By:	Date:	Drawing Number:							
		SAMPLE/2015/05/FA01							
Scale @ A1:	Date:								
1:100 (APPROX)	MAY 15	Revision:							

 

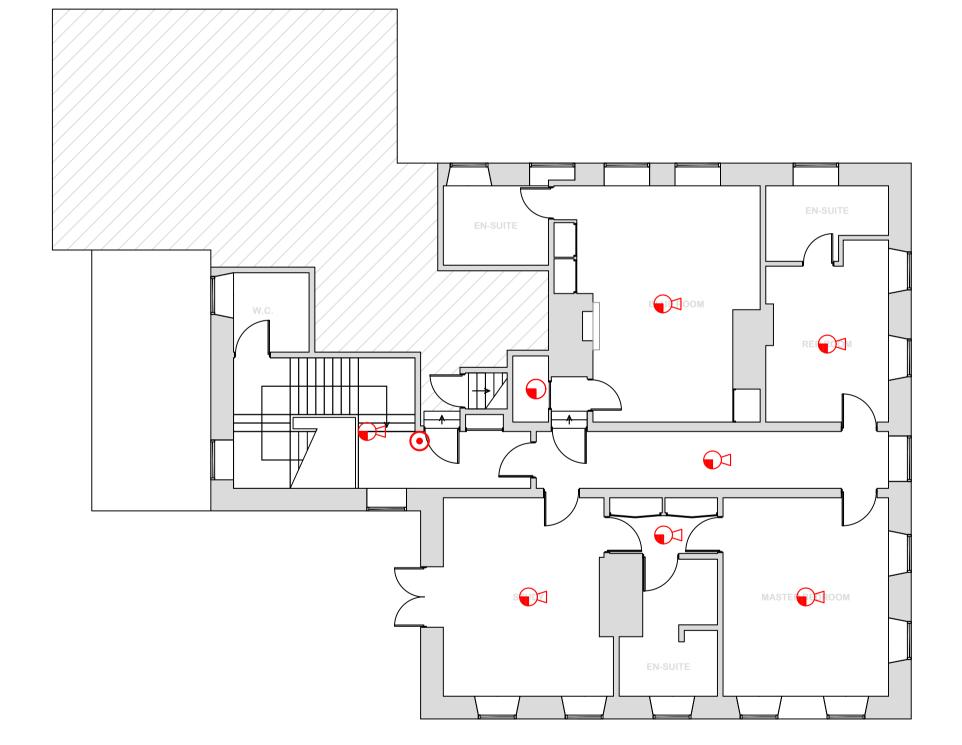


FIRST FLOOR


NOTES:




4 HERMITAGE CLOSE THREE LEGGED CROSS WIMBORNE DORSET BH21 6QA Tel: 07835 742300 Email: autocad_drawings@btinternet.c

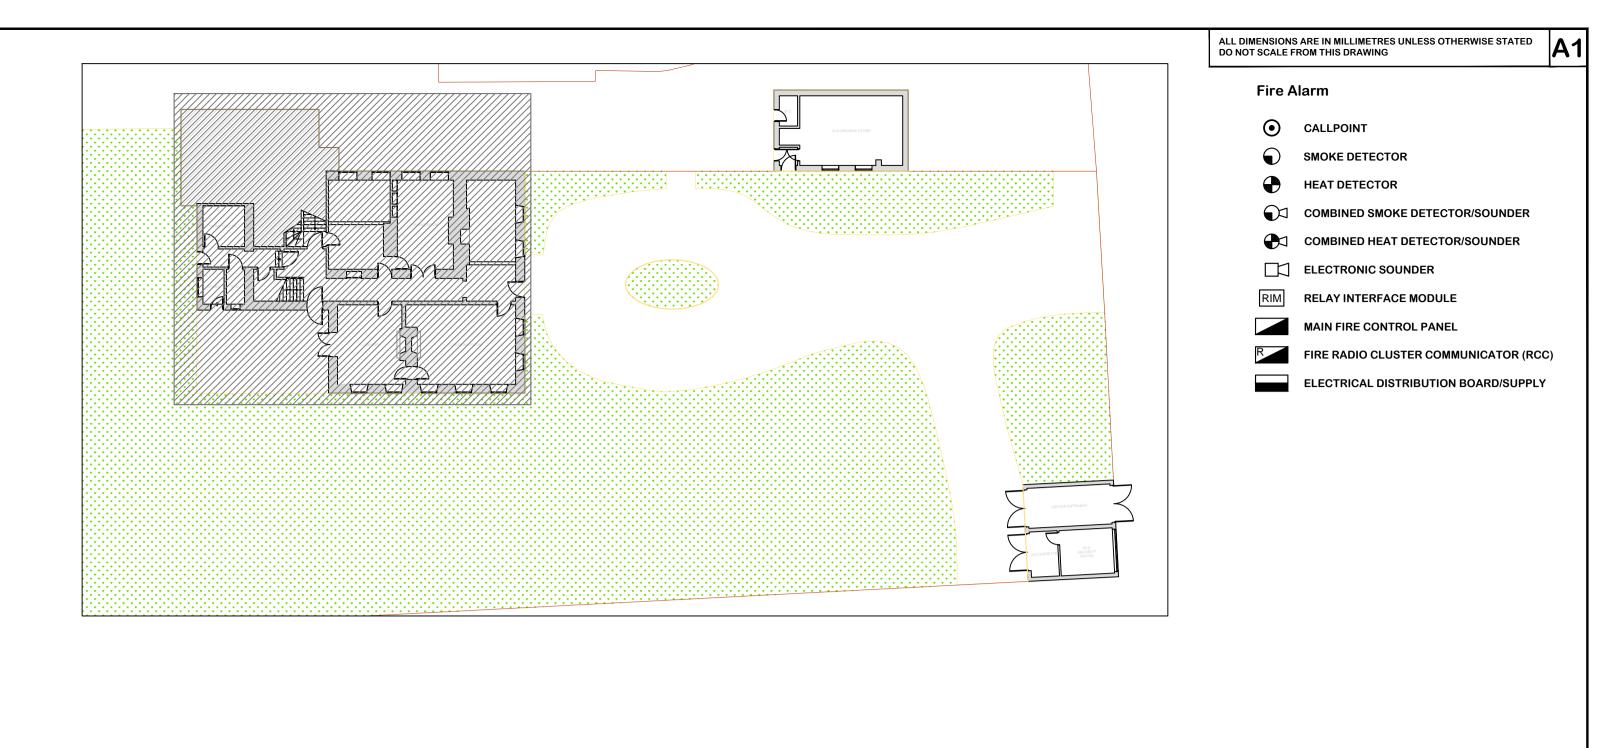

SITE PLAN - SCALE 1:250

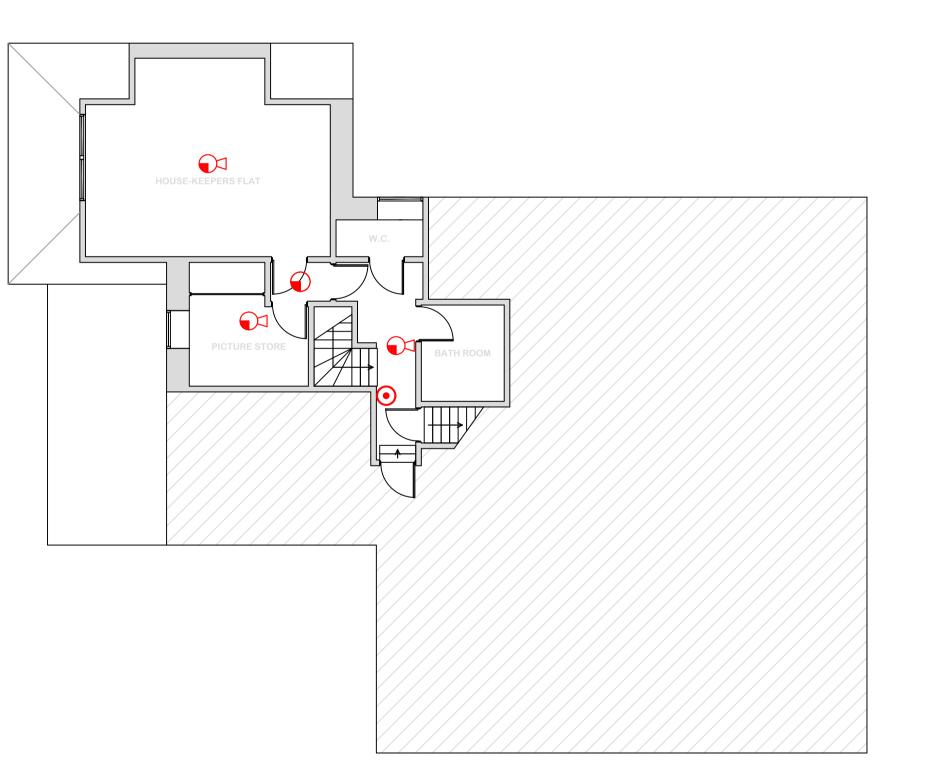

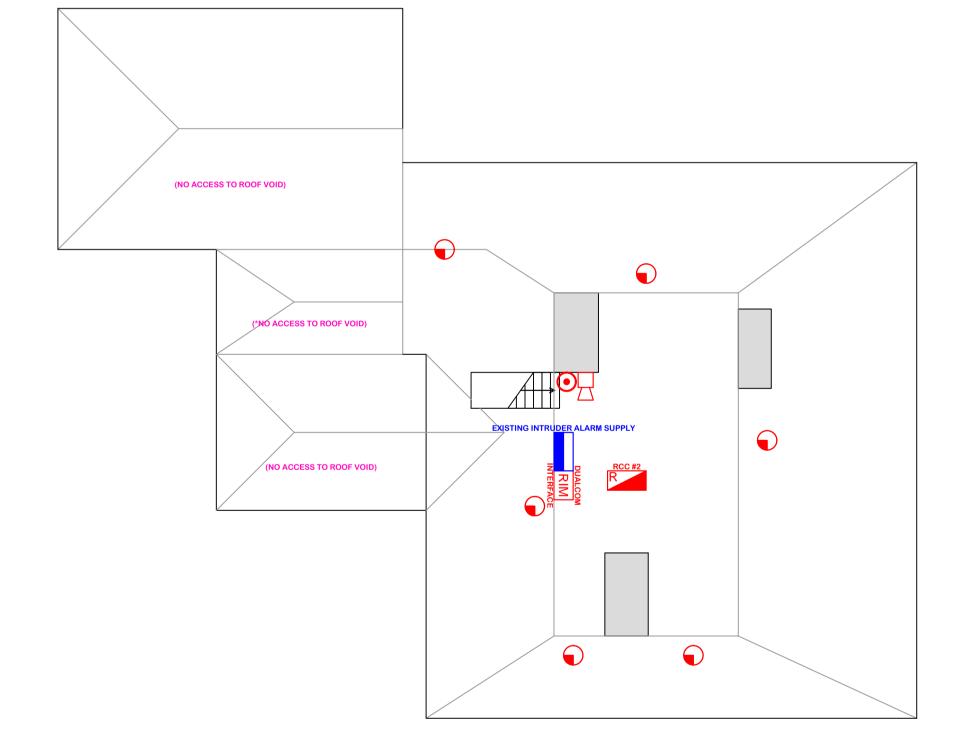

UPPER FIRST FLOOR


					Project:	Title:
					Arundells 59 The Close Salisbury Wiltshire	Proposed Fire Alarm System Replacement / Upgrade
t.com					SP1 2ER	MAIN HOUSE - UPPER FLOORS
	Revision	Description	Date	Checked		
		AMENDMENT RECORD)			

ROOF

Drawn By: ISW	Date: MAY 15	© This drawing and/or design is the property of 'LIFE SAFETY SYSTEMS' and shall not be reproduced or copied in the whole or part in any way or conveyed to a third party without the owners written permission.								
Checked By:	Date:	Drawing Number:								
		SAMPLE/2015/05/FA02								
Scale @ A1:	Date:									
1:100 (APPROX)	MAY 15	Revision:								



4 HERMITAGE CLOSE THREE LEGGED CROSS WIMBORNE DORSET BH21 6QA Tel: 07835 742300 Email: autocad_drawings@btinternet.co

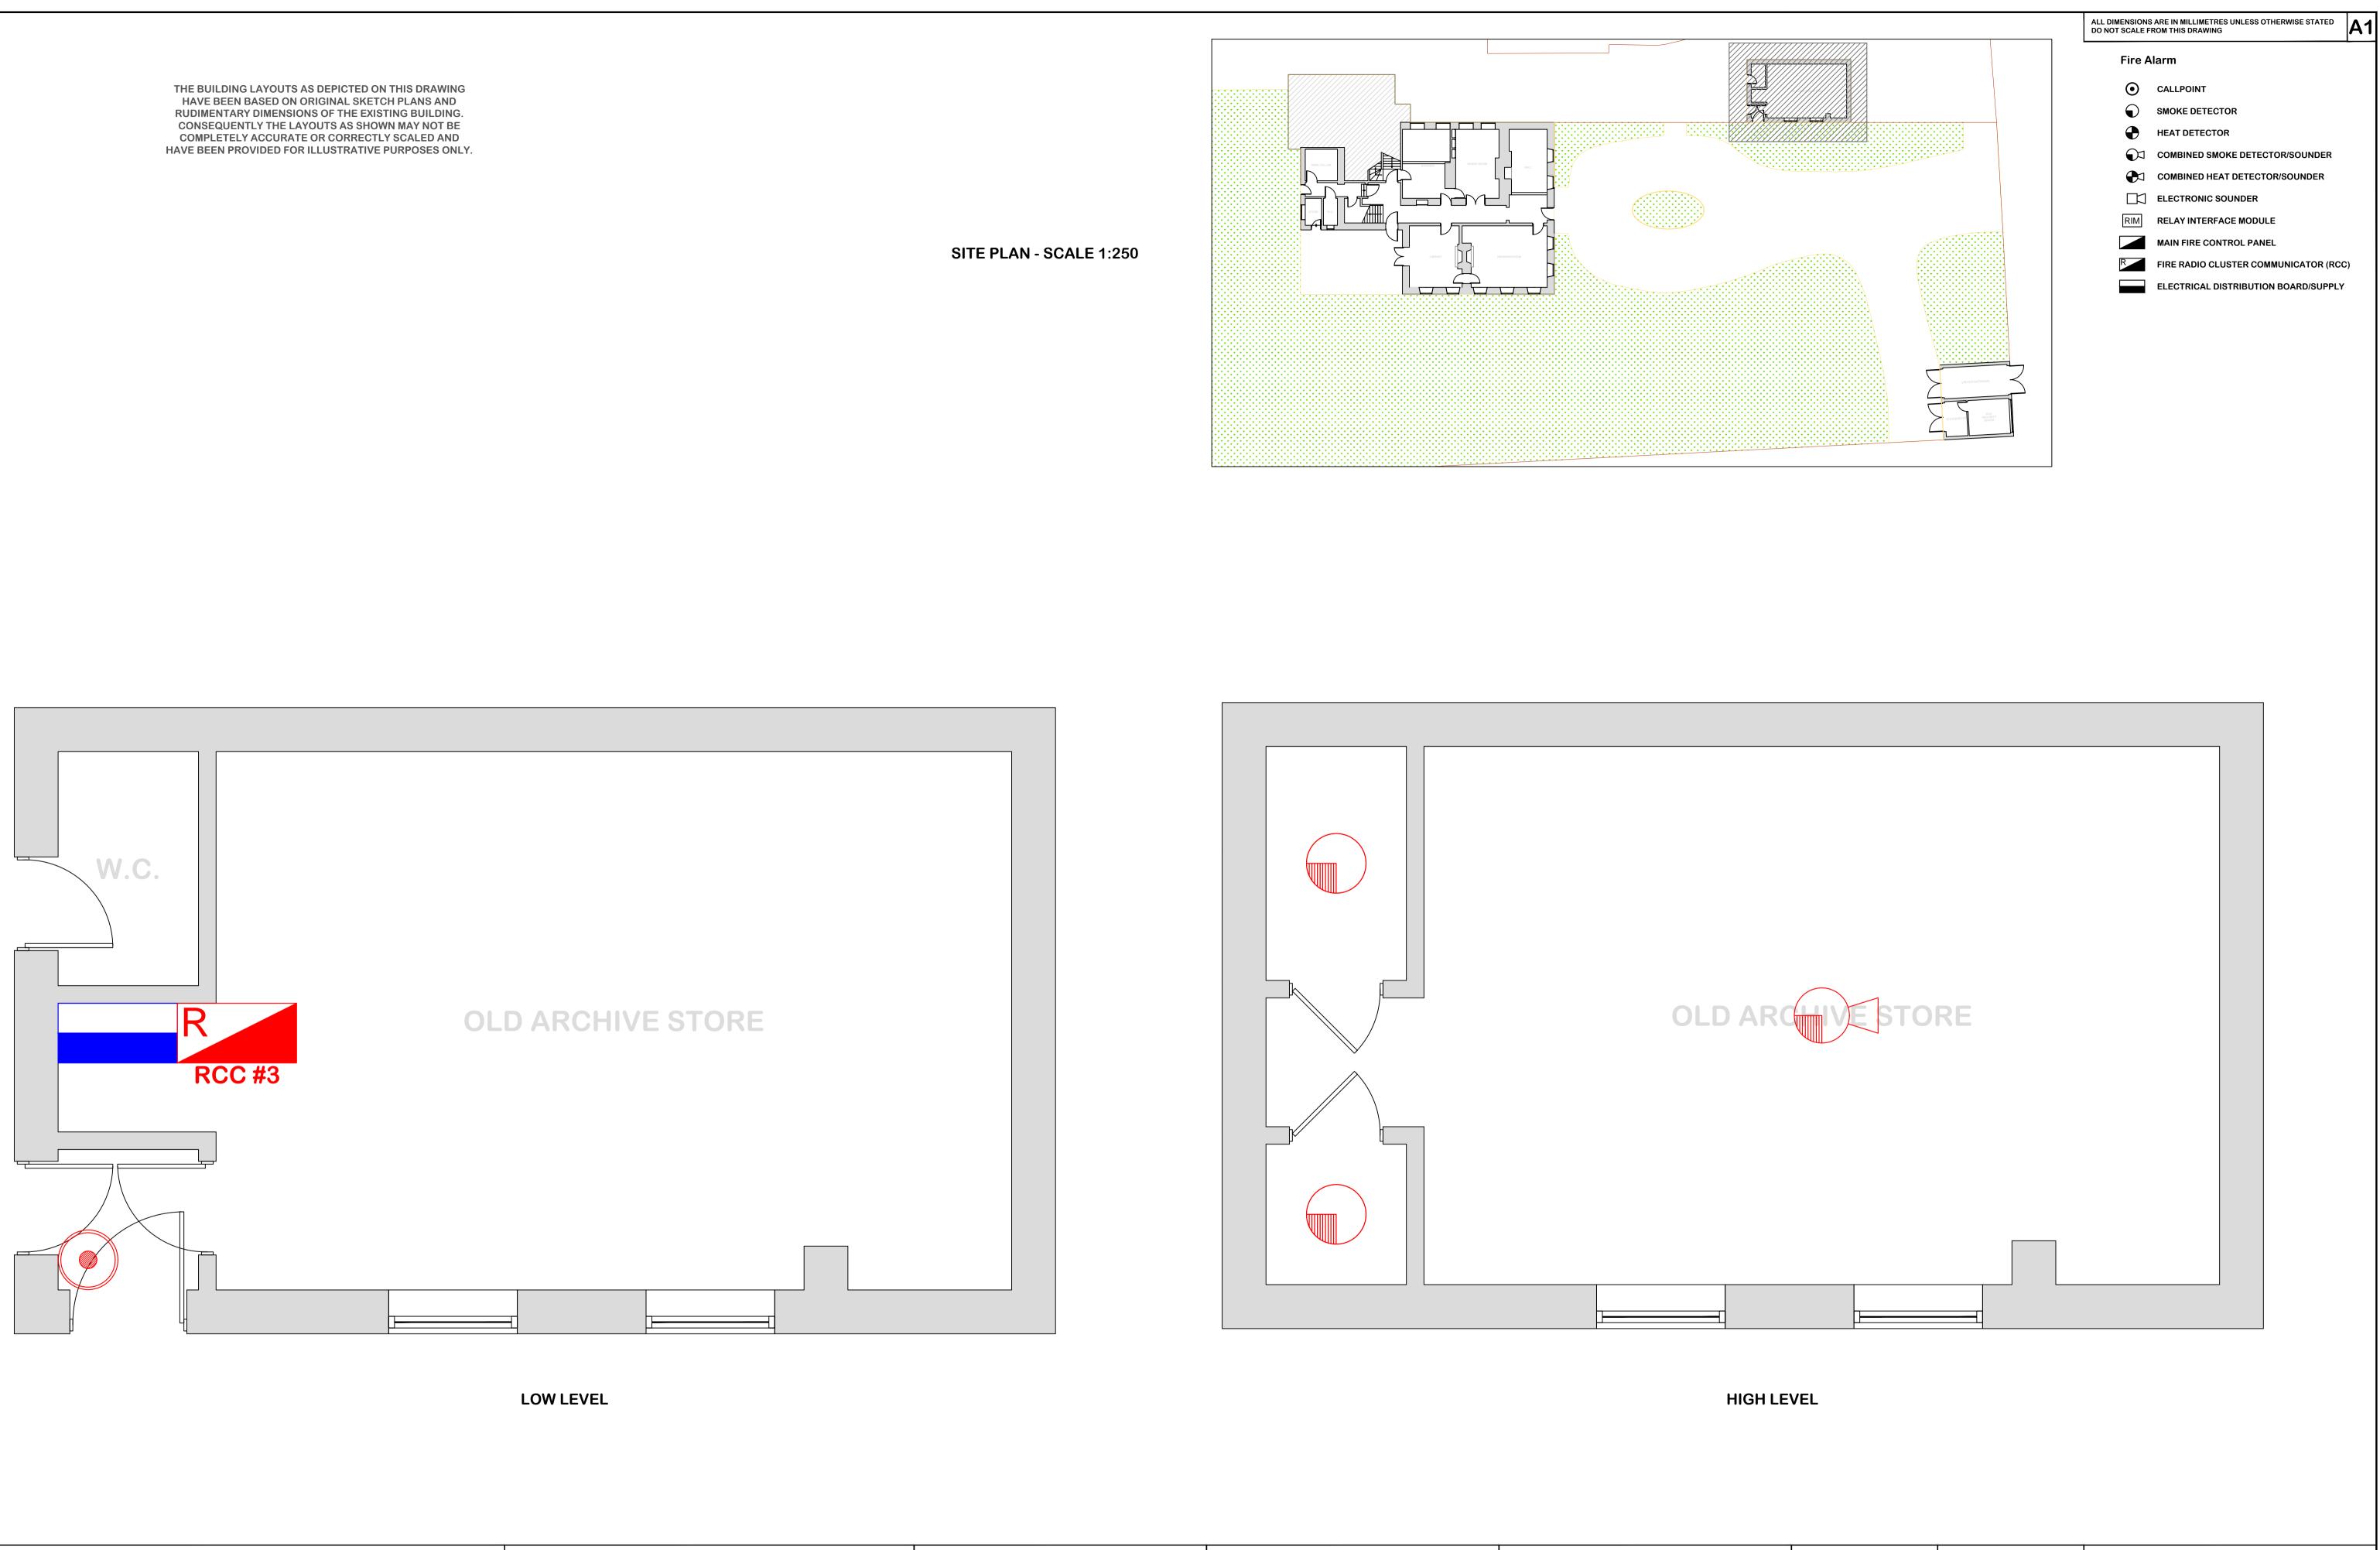


NOTES:



			Project: Arundells	Title: Proposed	Drawn By: ISW	Date:	MAY 15	© This drawing and/or reproduced or copied owners written permis	n the whole					the
			59 The Close Salisbury Wiltshire	Fire Alarm System Replacement / Upgrade	Checked By:	Date:		Drawing Number		E/20)15/)5/F	A03	
com	Revision Description Date	Checked	SP1 2ER	ARCHIVE STORE	Scale@A1: 1:25 (APPROX)	Date:	MAY 15	Revision:						
	AMENDMENT RECORD				1.23 (AFT KOX)									


THE BUILDING LAYOUTS AS DEPICTED ON THIS DRAWING HAVE BEEN BASED ON ORIGINAL SKETCH PLANS AND RUDIMENTARY DIMENSIONS OF THE EXISTING BUILDING. CONSEQUENTLY THE LAYOUTS AS SHOWN MAY NOT BE COMPLETELY ACCURATE OR CORRECTLY SCALED AND HAVE BEEN PROVIDED FOR ILLUSTRATIVE PURPOSES ONLY.

NOTES:

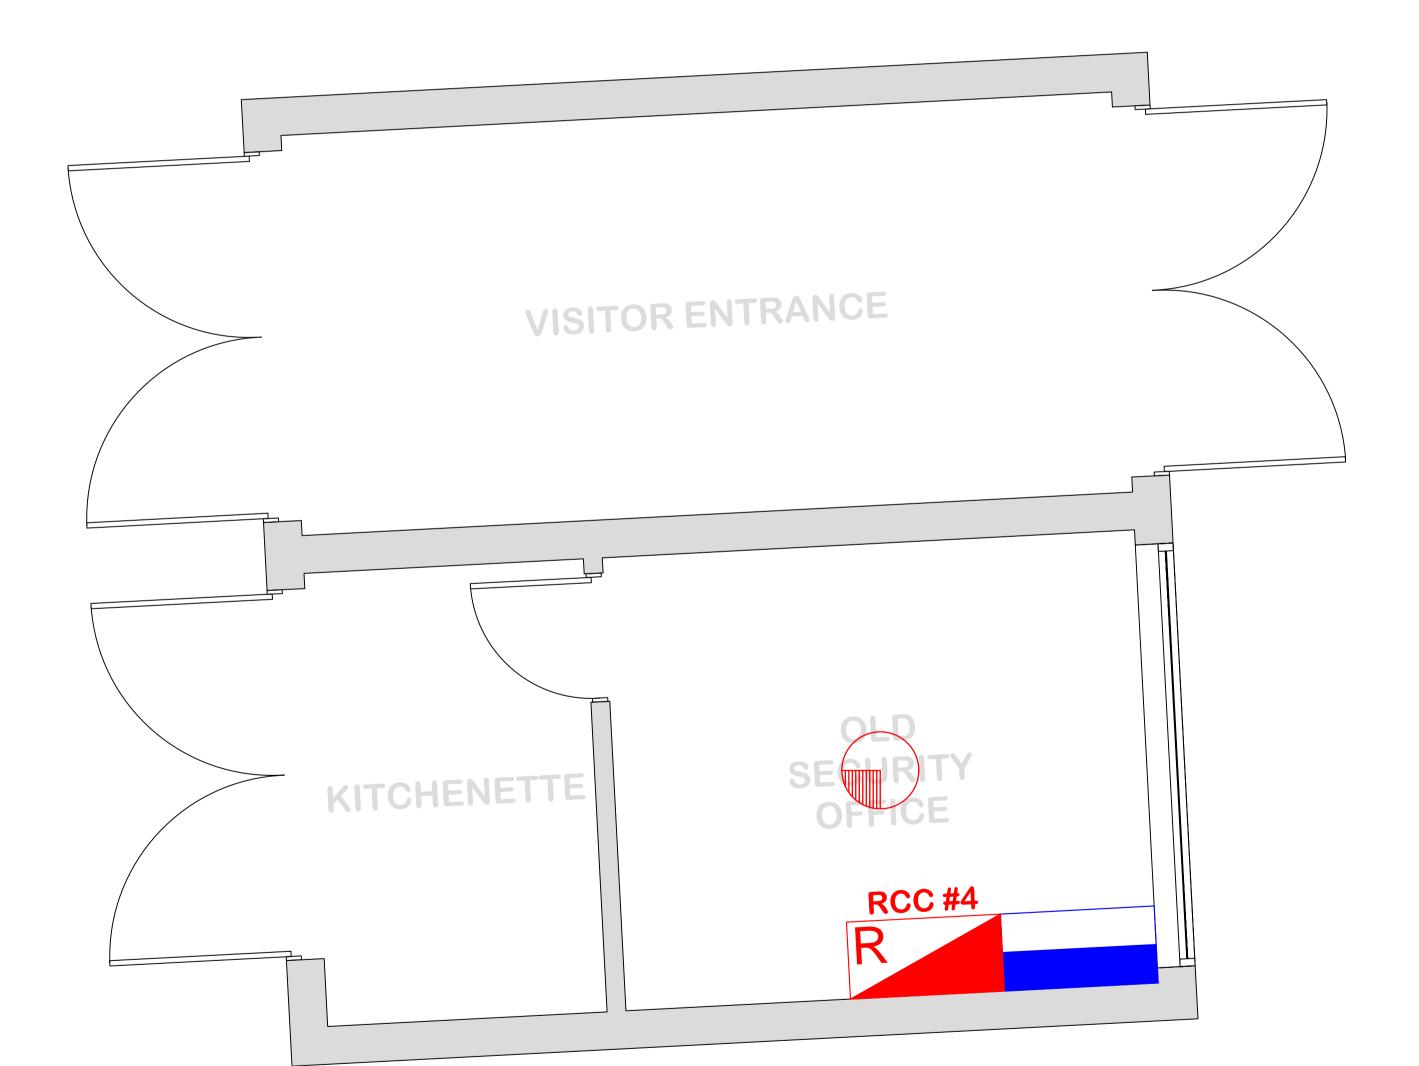



4 HERMITAGE CLOSE THREE LEGGED CROSS WIMBORNE DORSET BH21 6QA Tel: 07835 742300 Email: autocad_drawings@btinternet.c

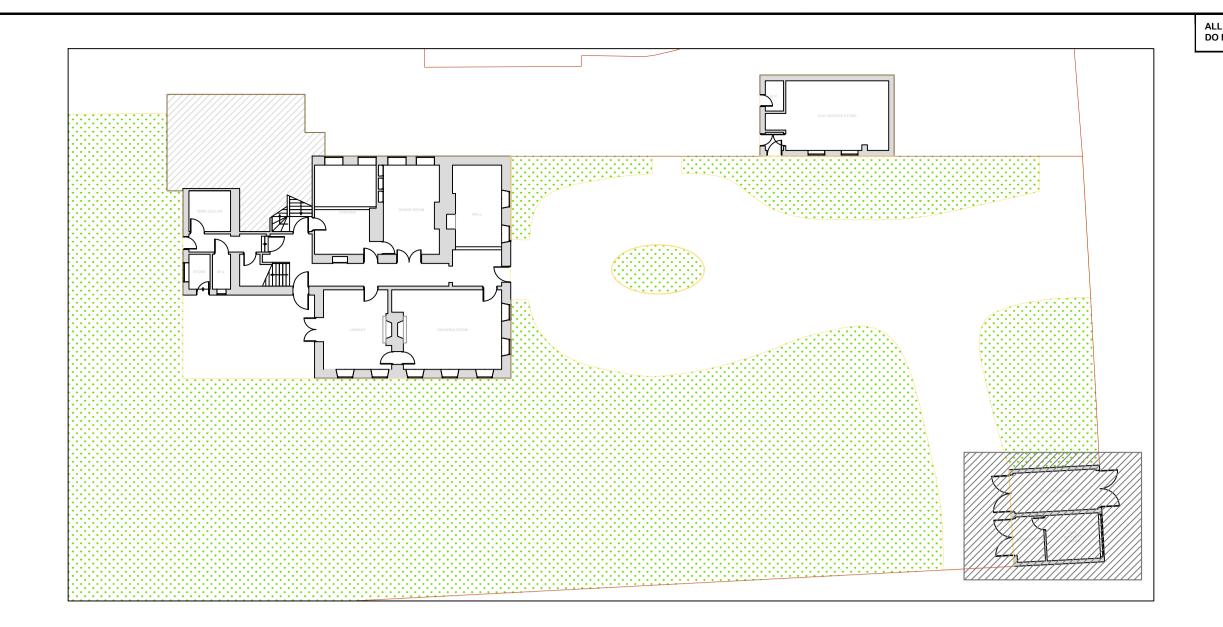

SITE PLAN - SCALE 1:250

					Project:	Title:
et.com					Arundells 59 The Close Salisbury Wiltshire SP1 2ER	Proposed Fire Alarm System Replacement / Upgrade GARAGE
	Revision	Description	Date	Checked		
		AMENDMENT RECORD)			

LL DIMENSIONS ARE IN MILLIMETRES UNLESS OTHERWISE STATED NO NOT SCALE FROM THIS DRAWING										
Fire Alarm										
\odot	CALLPOINT									
\mathbf{O}	SMOKE DETECTOR									
	HEAT DETECTOR									
$\bigcirc \neg$	COMBINED SMOKE DETECTOR/SOUNDER									
	COMBINED HEAT DETECTOR/SOUNDER									
	ELECTRONIC SOUNDER									
RIM	RELAY INTERFACE MODULE									
	MAIN FIRE CONTROL PANEL									
R	FIRE RADIO CLUSTER COMMUNICATOR (RCC)								
	ELECTRICAL DISTRIBUTION BOARD/SUPPLY									

Drawn By: Date: ISW MAY 15		© This drawing and/or design is the property of 'LIFE SAFETY SYSTEMS' and shall not be reproduced or copied in the whole or part in any way or conveyed to a third party without the owners written permission.								
Checked By:	Date:	Drawing Number:								
		SAMPLE/2015/05/FA04								
Scale @ A1:	Date:									
1:25 (APPROX)	MAY 15	Revision:								