


BASEMENT


NOTES:




4 HERMITAGE CLOSE THREE LEGGED CROSS WIMBORNE DORSET BH21 6QA Tel: 07835 742300 Email: autocad_drawings@btinternet.co

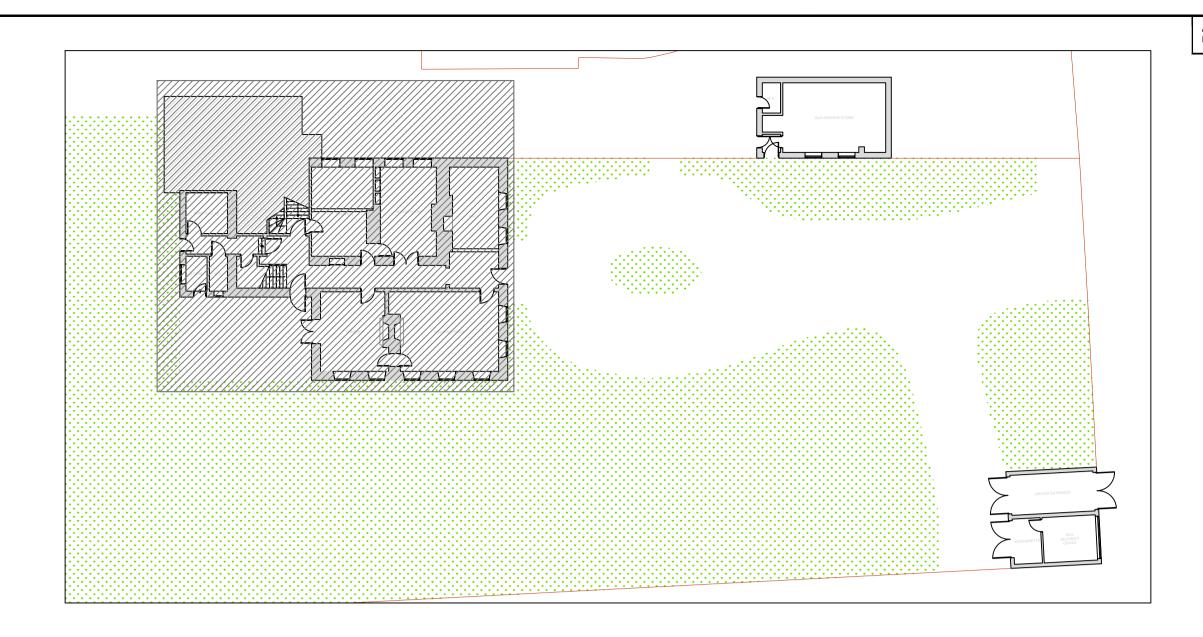

SITE PLAN - SCALE 1:250

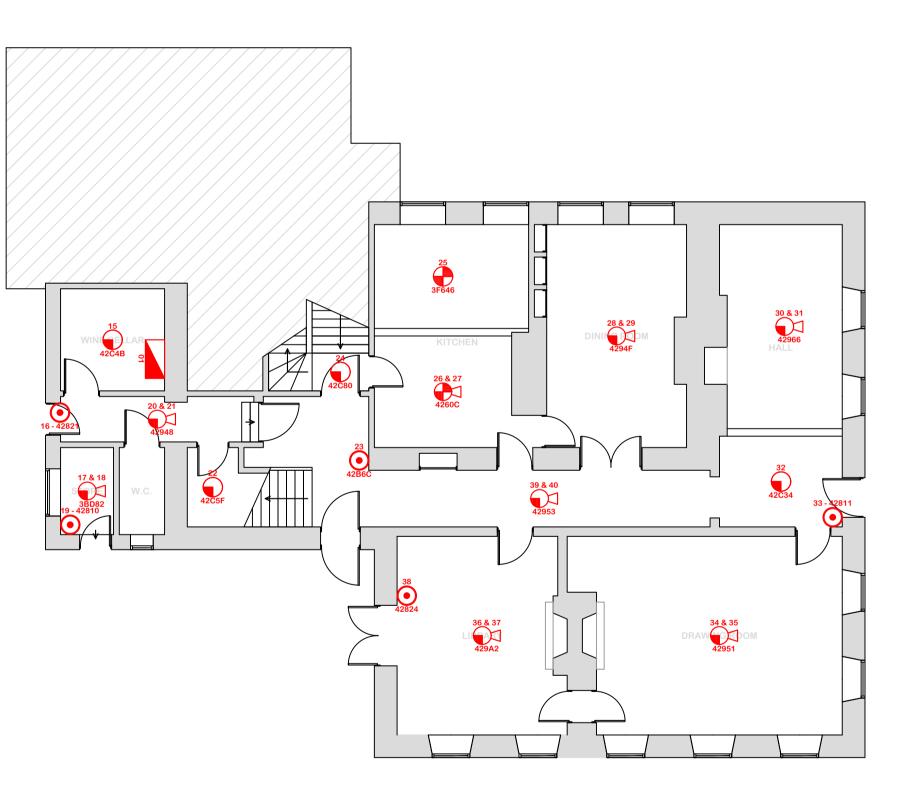

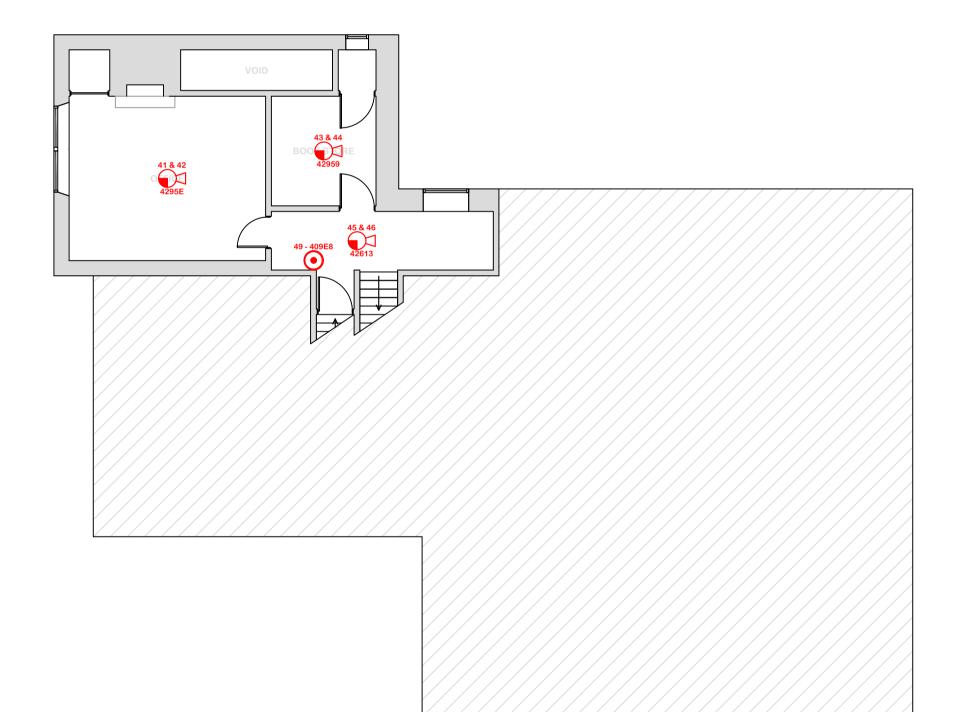


GROUND FLOOR


			Project: Arundells 59 The Close Salisbury	Title: Proposed Fire Alarm System Replacement / Upgrade			
com					Wiltshire SP1 2ER	MAIN HOUSE - LOWER FLOORS	
	Revision	Description	Date	Checked		(RECORD DRAWING)	
AMENDMENT RECORD					(RECORD DRAWING)		

	ALL DIMENSIONS ARE IN MILLIMETRES UNLESS OTHERWISE STATED DO NOT SCALE FROM THIS DRAWING						
Fire Alarm							
ullet	CALLPOINT						
\mathbf{O}	SMOKE DETECTOR						
	HEAT DETECTOR						
$\mathbf{O}^{\mathbf{I}}$	COMBINED SMOKE DETECTOR/SOUNDER						
	COMBINED HEAT DETECTOR/SOUNDER						
	ELECTRONIC SOUNDER						
RIM	RELAY INTERFACE MODULE						
	MAIN FIRE CONTROL PANEL						
R	FIRE RADIO CLUSTER COMMUNICATOR (RCC)					
	ELECTRICAL DISTRIBUTION BOARD/SUPPLY						

LOWER FIRST FLOOR

Drawn By: ISW	Date: DEC 15	© This drawing and/or design is the property of 'LIFE SAFETY SYSTEMS' and shall not be reproduced or copied in the whole or part in any way or conveyed to a third party without the owners written permission.								
Checked By:	Date:	Drawing Number:								
		SAMPLE/2015/05/FA100								
Scale @ A1:	Date:									
1:100 (APPROX)	DEC 15	Revision:								

 

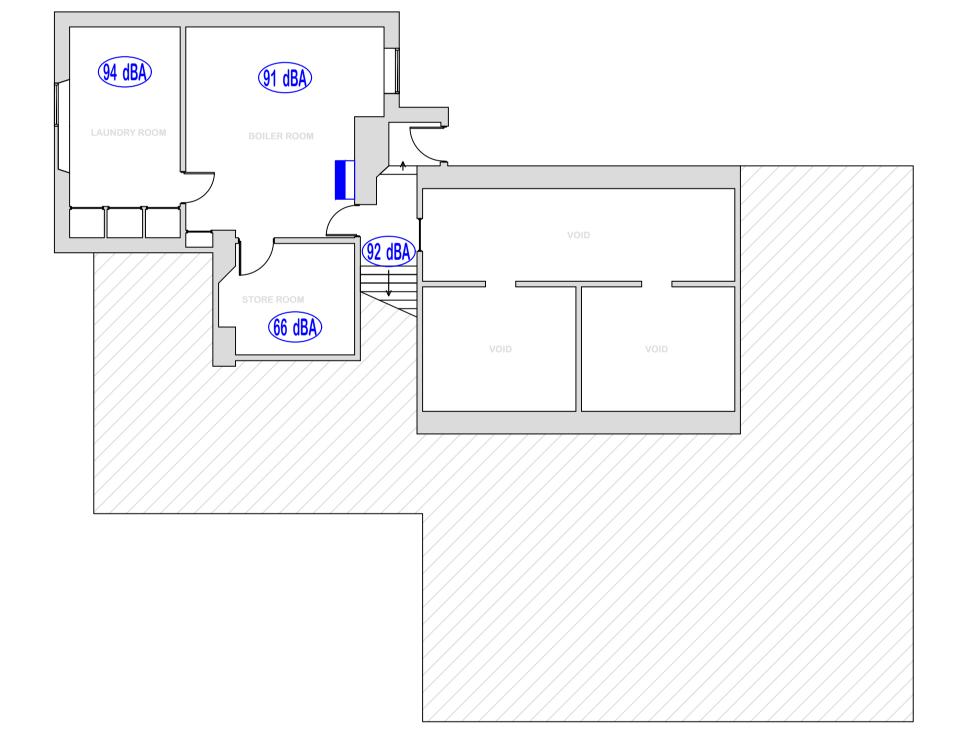


BASEMENT


NOTES:




4 HERMITAGE CLOSE THREE LEGGED CROSS WIMBORNE DORSET BH21 6QA Tel: 07835 742300 Email: autocad_drawings@btinternet.co

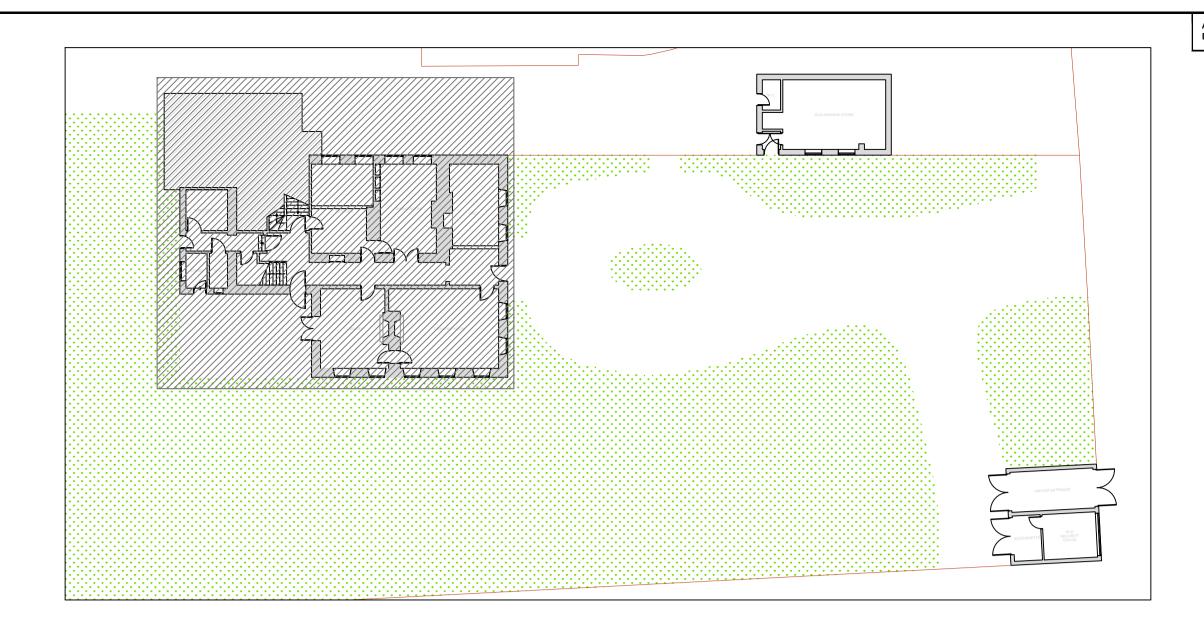

SITE PLAN - SCALE 1:250

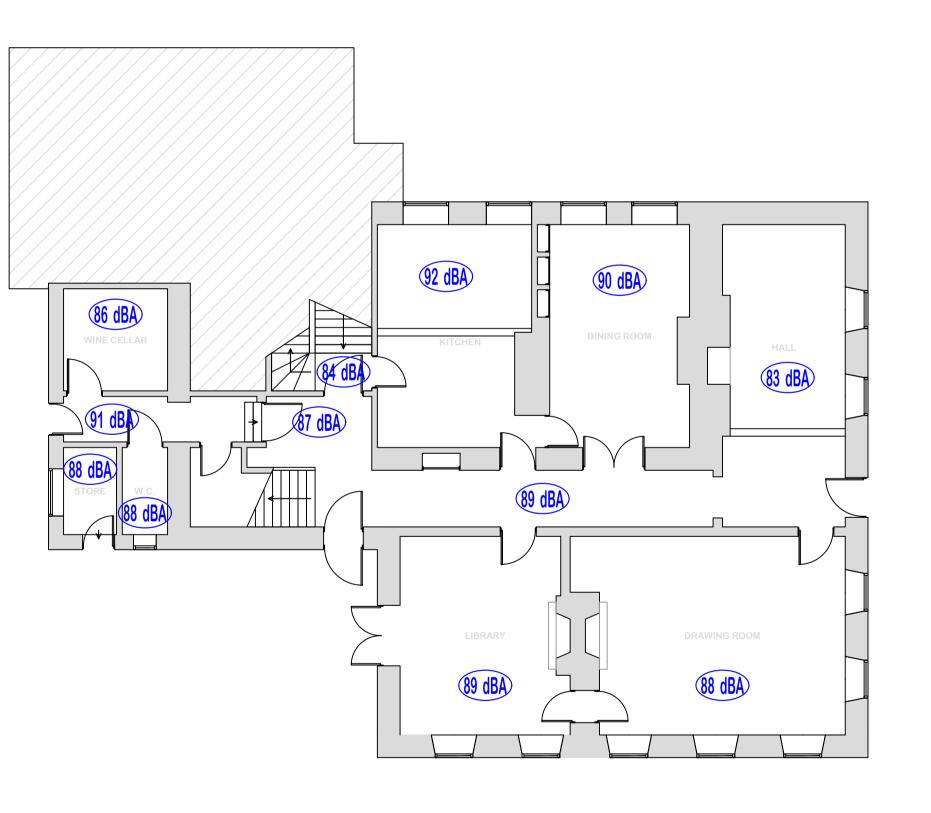

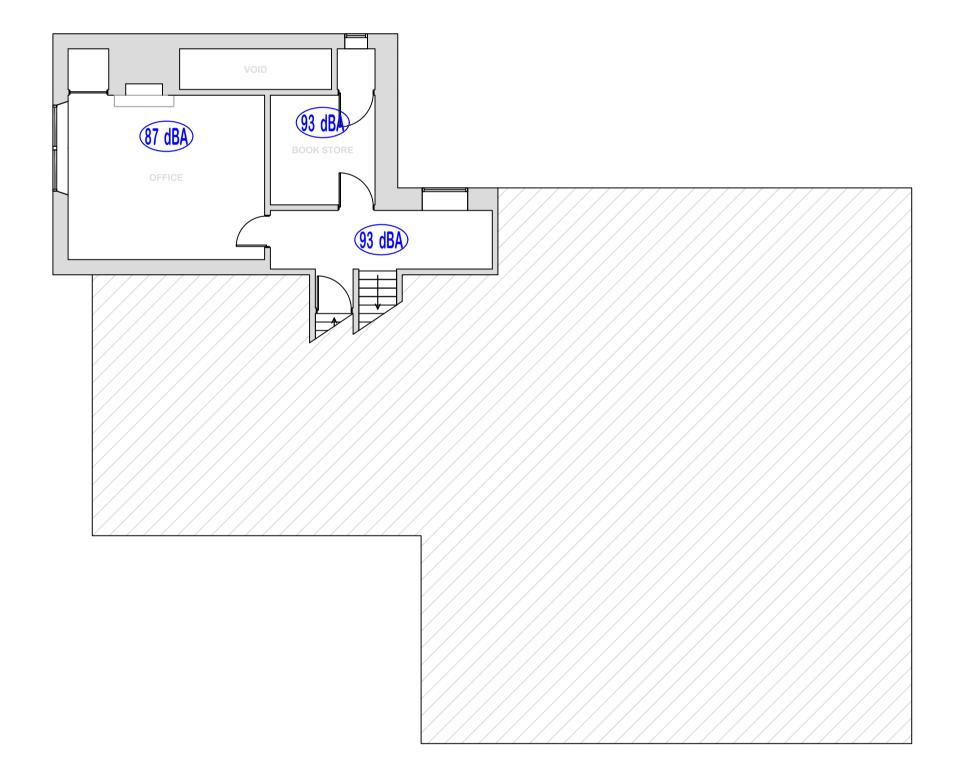


GROUND FLOOR


					Project:	Title:
					Arundells 59 The Close Salisbury Wiltshire SP1 2ER	Proposed Fire Alarm System Replacement / Upgrade MAIN HOUSE - LOWER FLOORS
.com	Revision	Description	Date	Checked		AUDIBILITY LEVELS
		AMENDMENT RECORD		oncokeu		(RECORD DRAWING)

LOWER FIRST FLOOR

Drawn By: ISW	Date: DEC 15	© This drawing and/or design is the property of 'LIFE SAFETY SYSTEMS' and shall not be reproduced or copied in the whole or part in any way or conveyed to a third party without the owners written permission.					
Checked By:	Date:	Drawing Number: SAMPLE/2015/05/FA101					
Scale @ A1: 1:100 (APPROX)	Date: DEC 15	Revision:					

 ALL DIMENSIONS ARE IN MILLIMETRES UNLESS OTHERWISE STATED DO NOT SCALE FROM THIS DRAWING



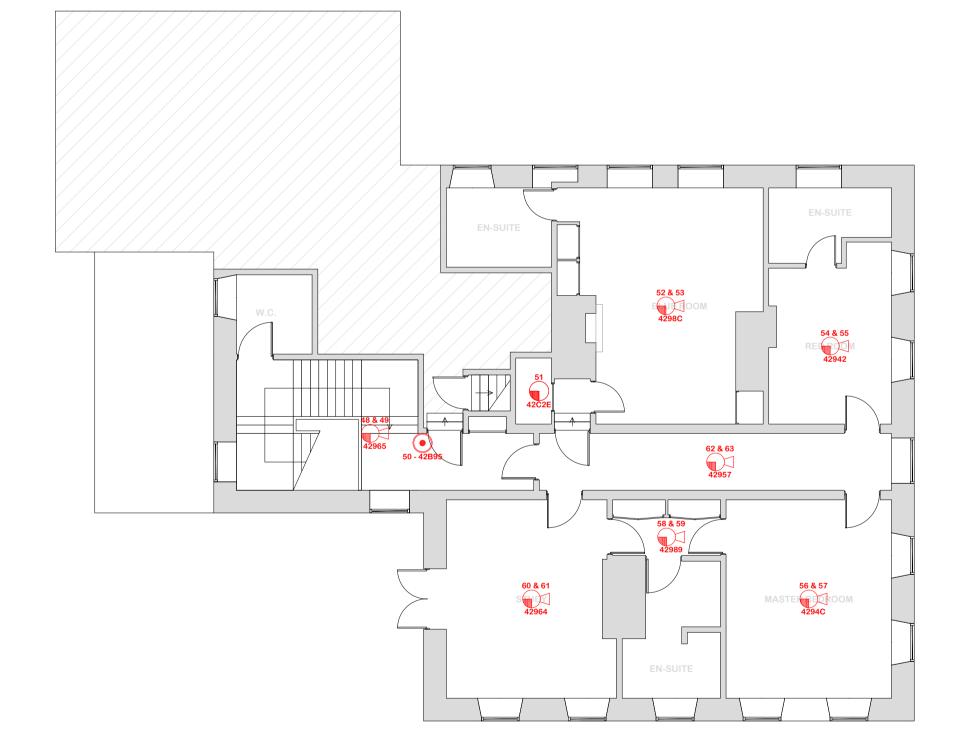


FIRST FLOOR


NOTES:




4 HERMITAGE CLOSE THREE LEGGED CROSS WIMBORNE DORSET BH21 6QA Tel: 07835 742300 Email: autocad_drawings@btinternet.co

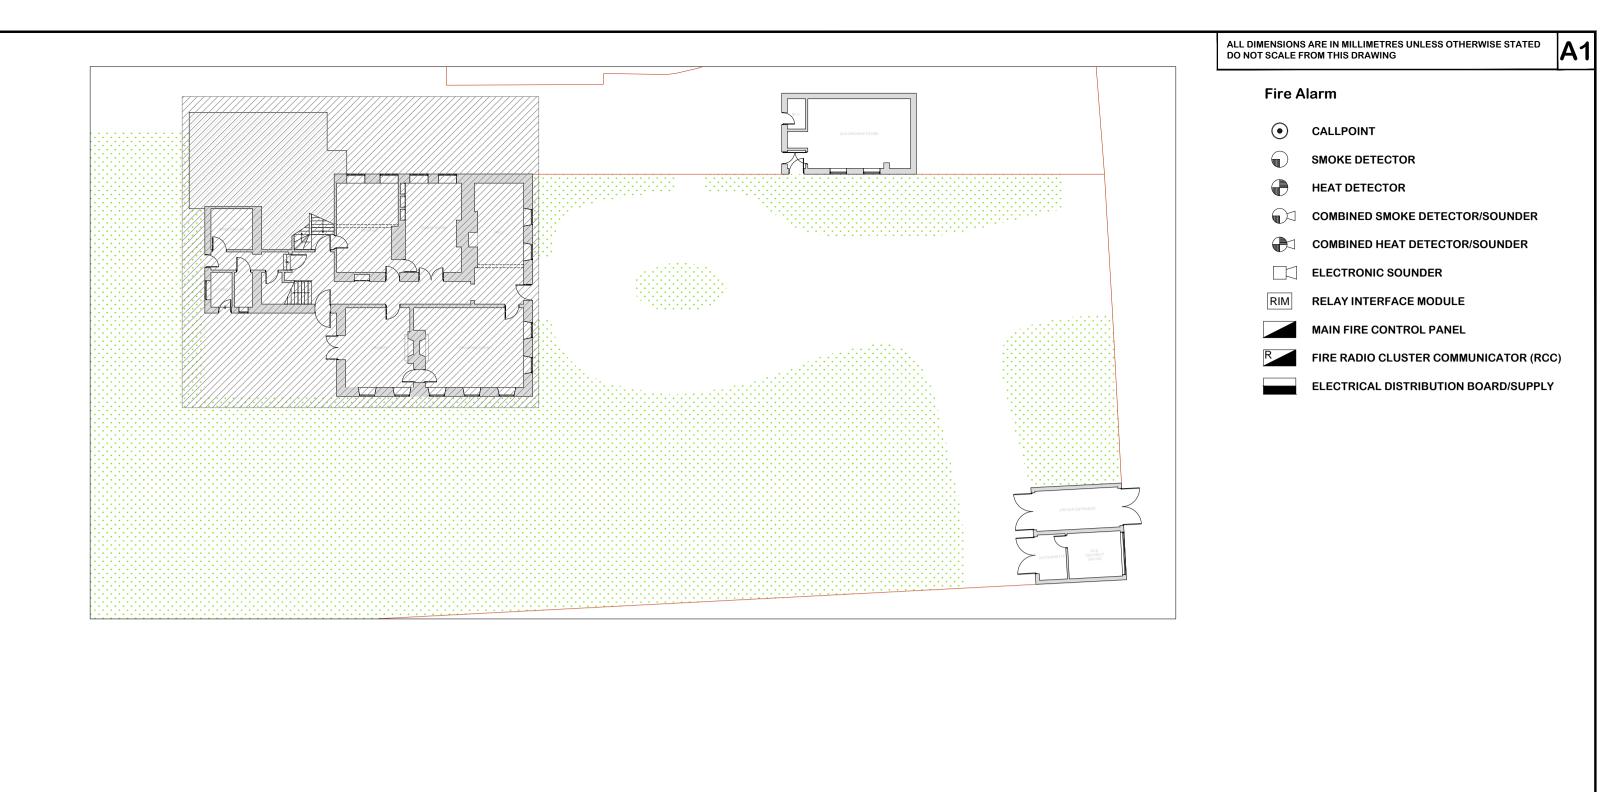

SITE PLAN - SCALE 1:250

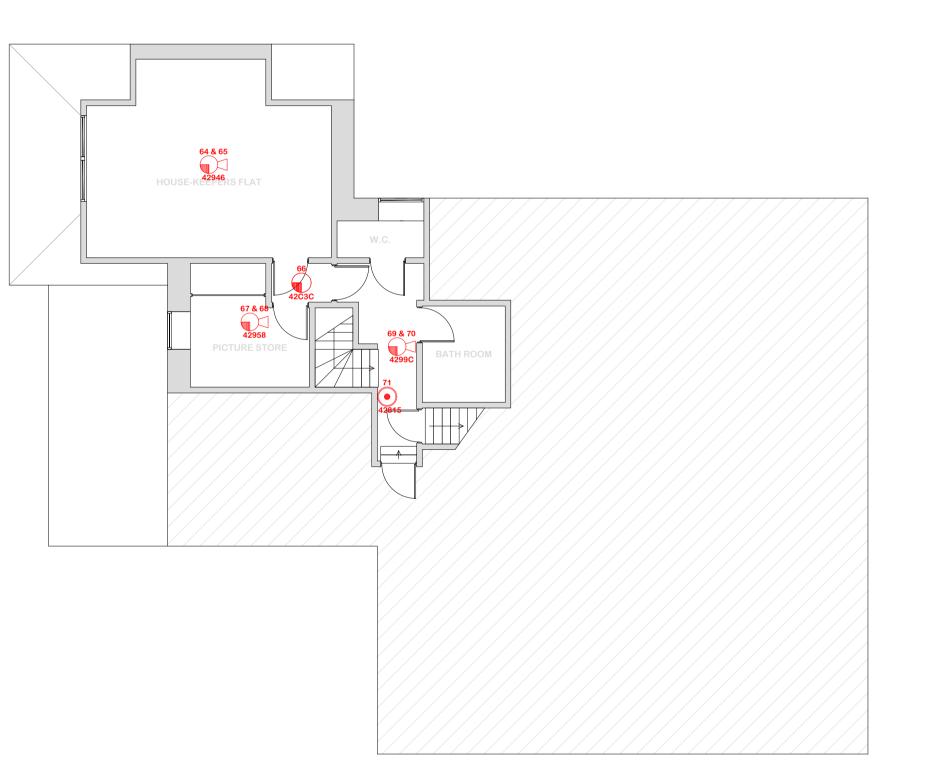

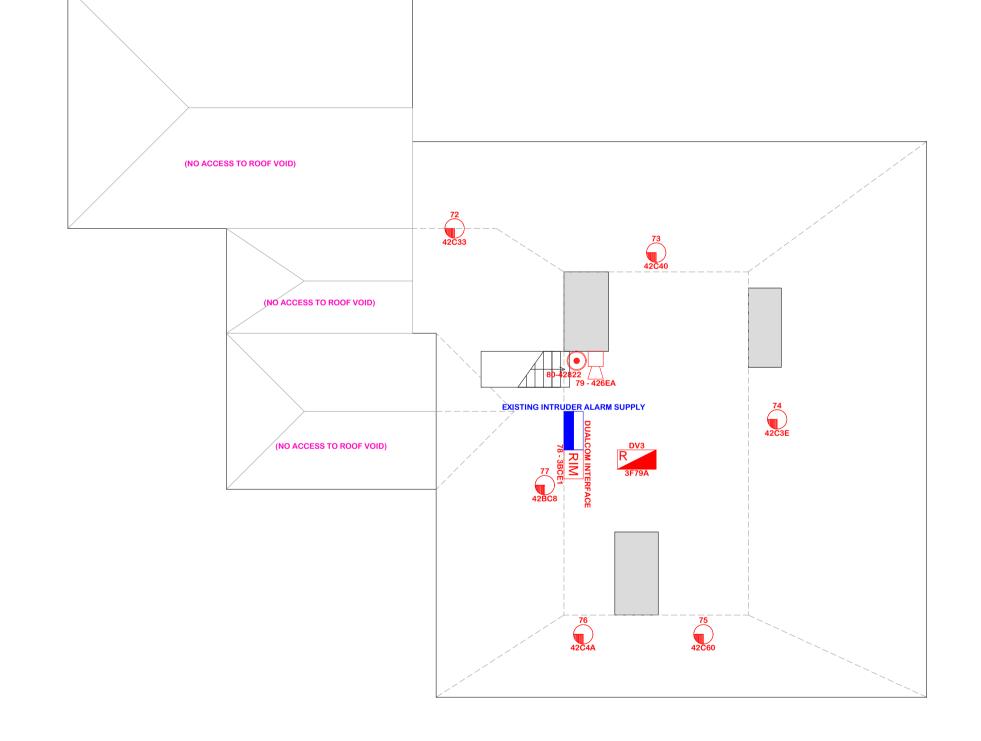



UPPER FIRST FLOOR

					Salisbury Wiltshire	Title: Proposed Fire Alarm System Replacement / Upgrade
t.com					SP1 2ER	MAIN HOUSE - UPPER FLOORS
	Revision	Description	Date	Checked		
		AMENDMENT RECORD)			(RECORD DRAWING)

ROOF

Drawn By:	Date:	© This drawing and/or design is the property of 'LIFE SAFETY SYSTEMS' and shall not be reproduced or copied in the whole or part in any way or conveyed to a third party without the						
ISW	DEC 15	owners written permission.						
Checked By:	Date:	Drawing Number:						
		SAMPLE/2015/05/FA110						
Scale @ A1:	Date:							
1:100 (APPROX)	DEC 15	Revision:						

 

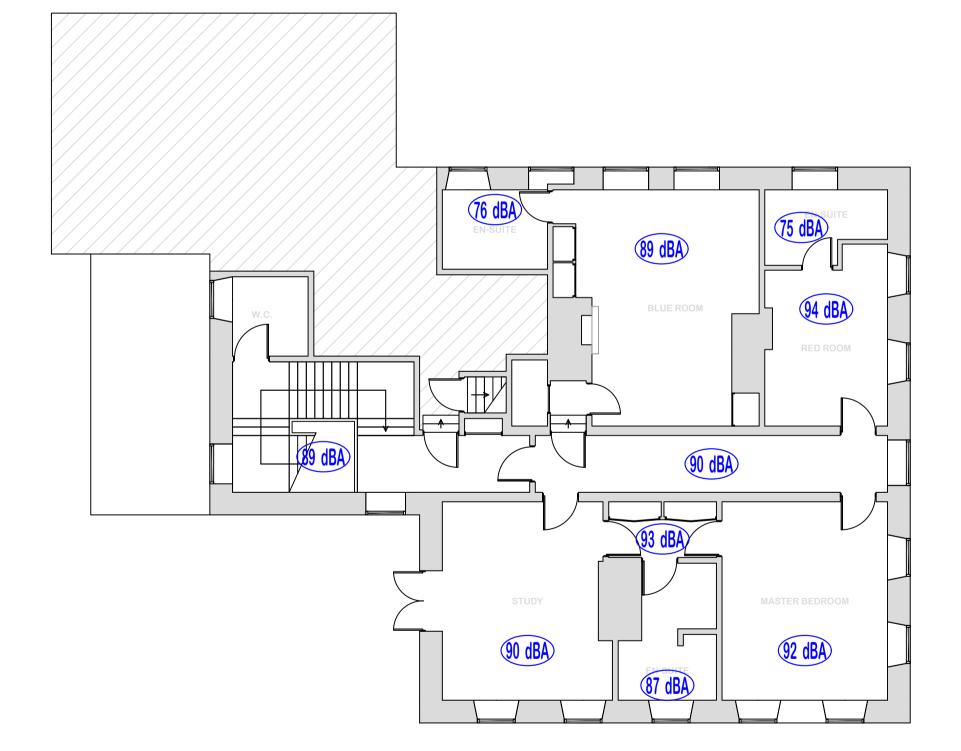


FIRST FLOOR


NOTES:




4 HERMITAGE CLOSE THREE LEGGED CROSS WIMBORNE DORSET BH21 6QA Tel: 07835 742300 Email: autocad_drawings@btinternet.co

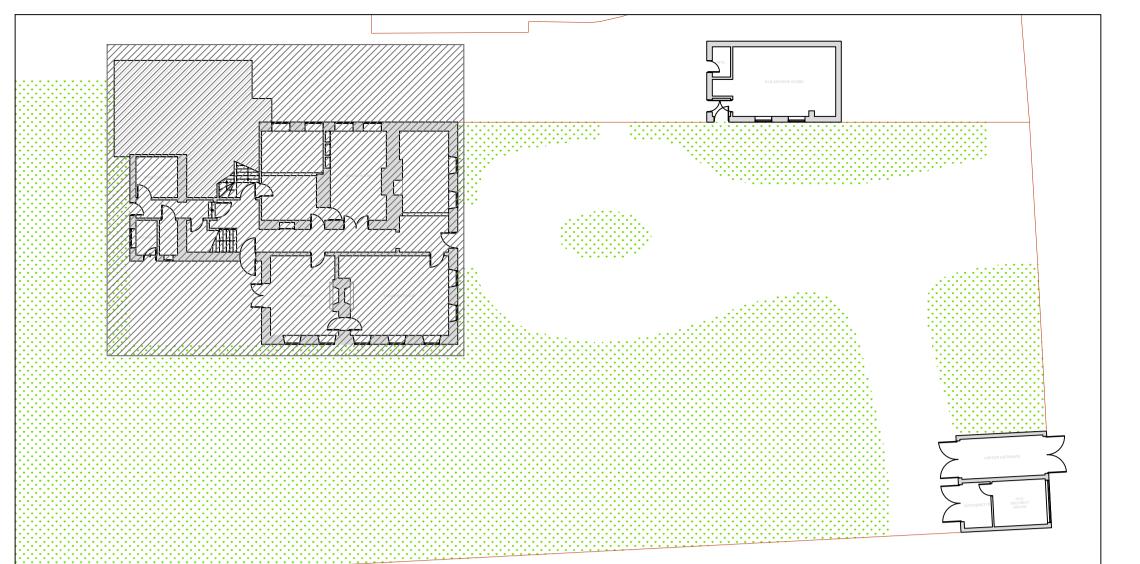

SITE PLAN - SCALE 1:250

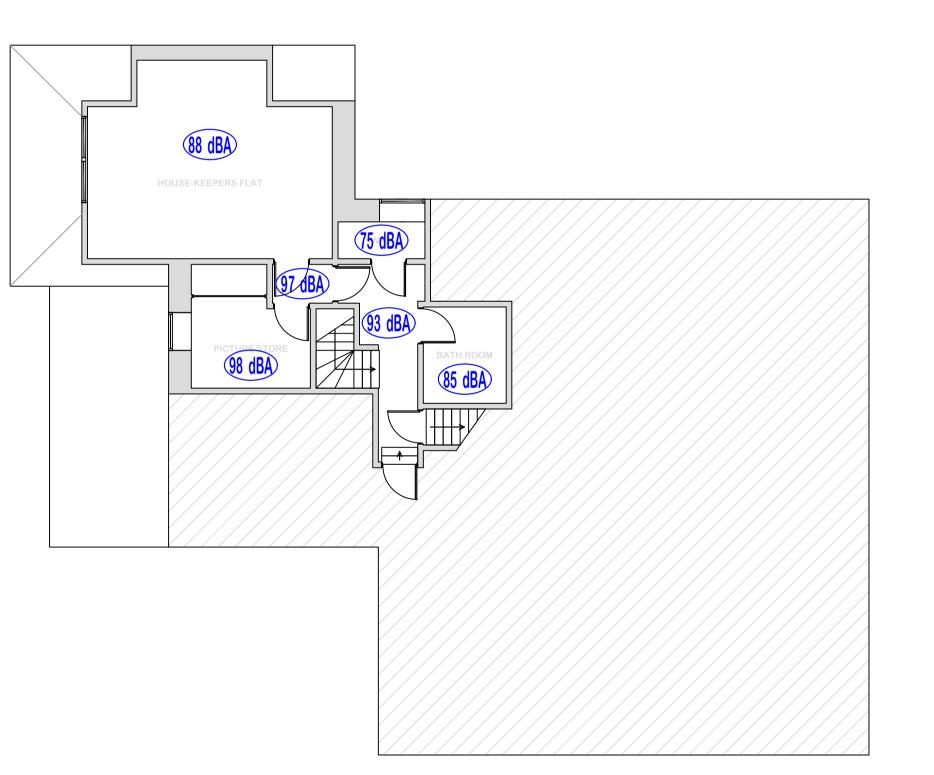

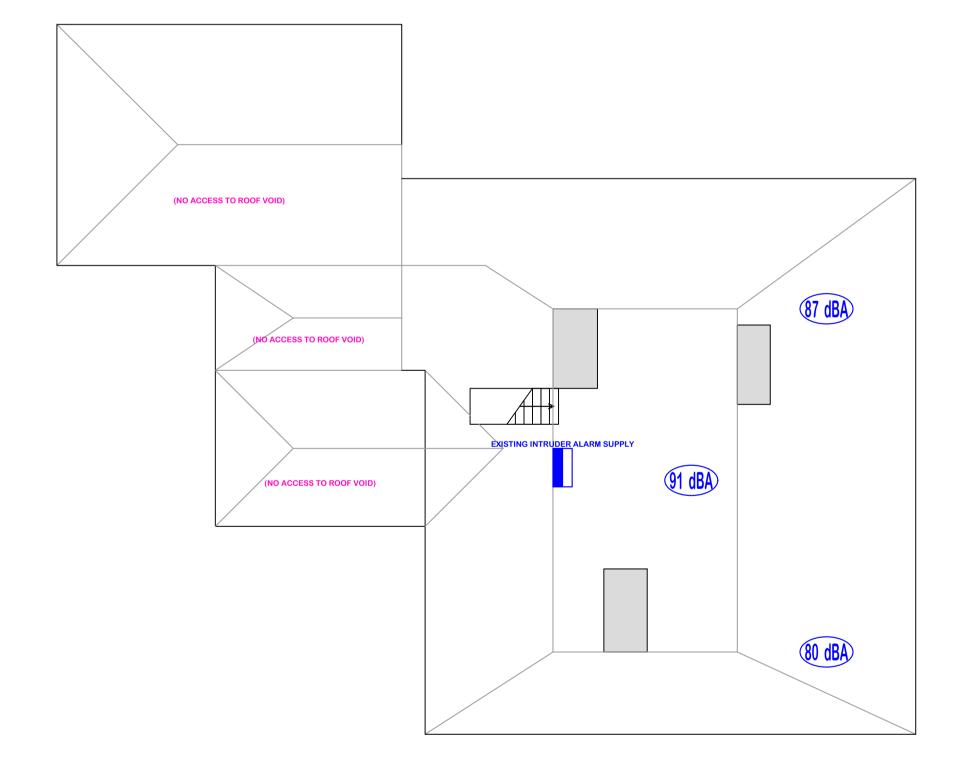

UPPER FIRST FLOOR

					Project:	Title:		
.com					Arundells 59 The Close Salisbury Wiltshire SP1 2ER	Proposed Fire Alarm System Replacement / Upgrade MAIN HOUSE - UPPER FLOORS		
	Revision	Description	Date	Checked				
AMENDMENT RECORD						(RECORD DRAWING)		

Drawn By: ISW				© This drawing and/or design is the property of 'LIFE SAFETY SYSTEMS' and shall not be reproduced or copied in the whole or part in any way or conveyed to a third party without the owners written permission.						
Checked By:	Date:	Drawing Number:								
		SA	MP	LE/	20 [.]	15/	05/1	FA1	111	
Scale @ A1:	Date:									
1:100 (APPROX)	DEC 15	Revision:								


ROOF


ALL DIMENSIONS ARE IN MILLIMETRES UNLESS OTHERWISE STATED DO NOT SCALE FROM THIS DRAWING



4 HERMITAGE CLOSE THREE LEGGED CROSS WIMBORNE DORSET BH21 6QA Tel: 07835 742300 Email: autocad_drawings@btinternet.co

NOTES:

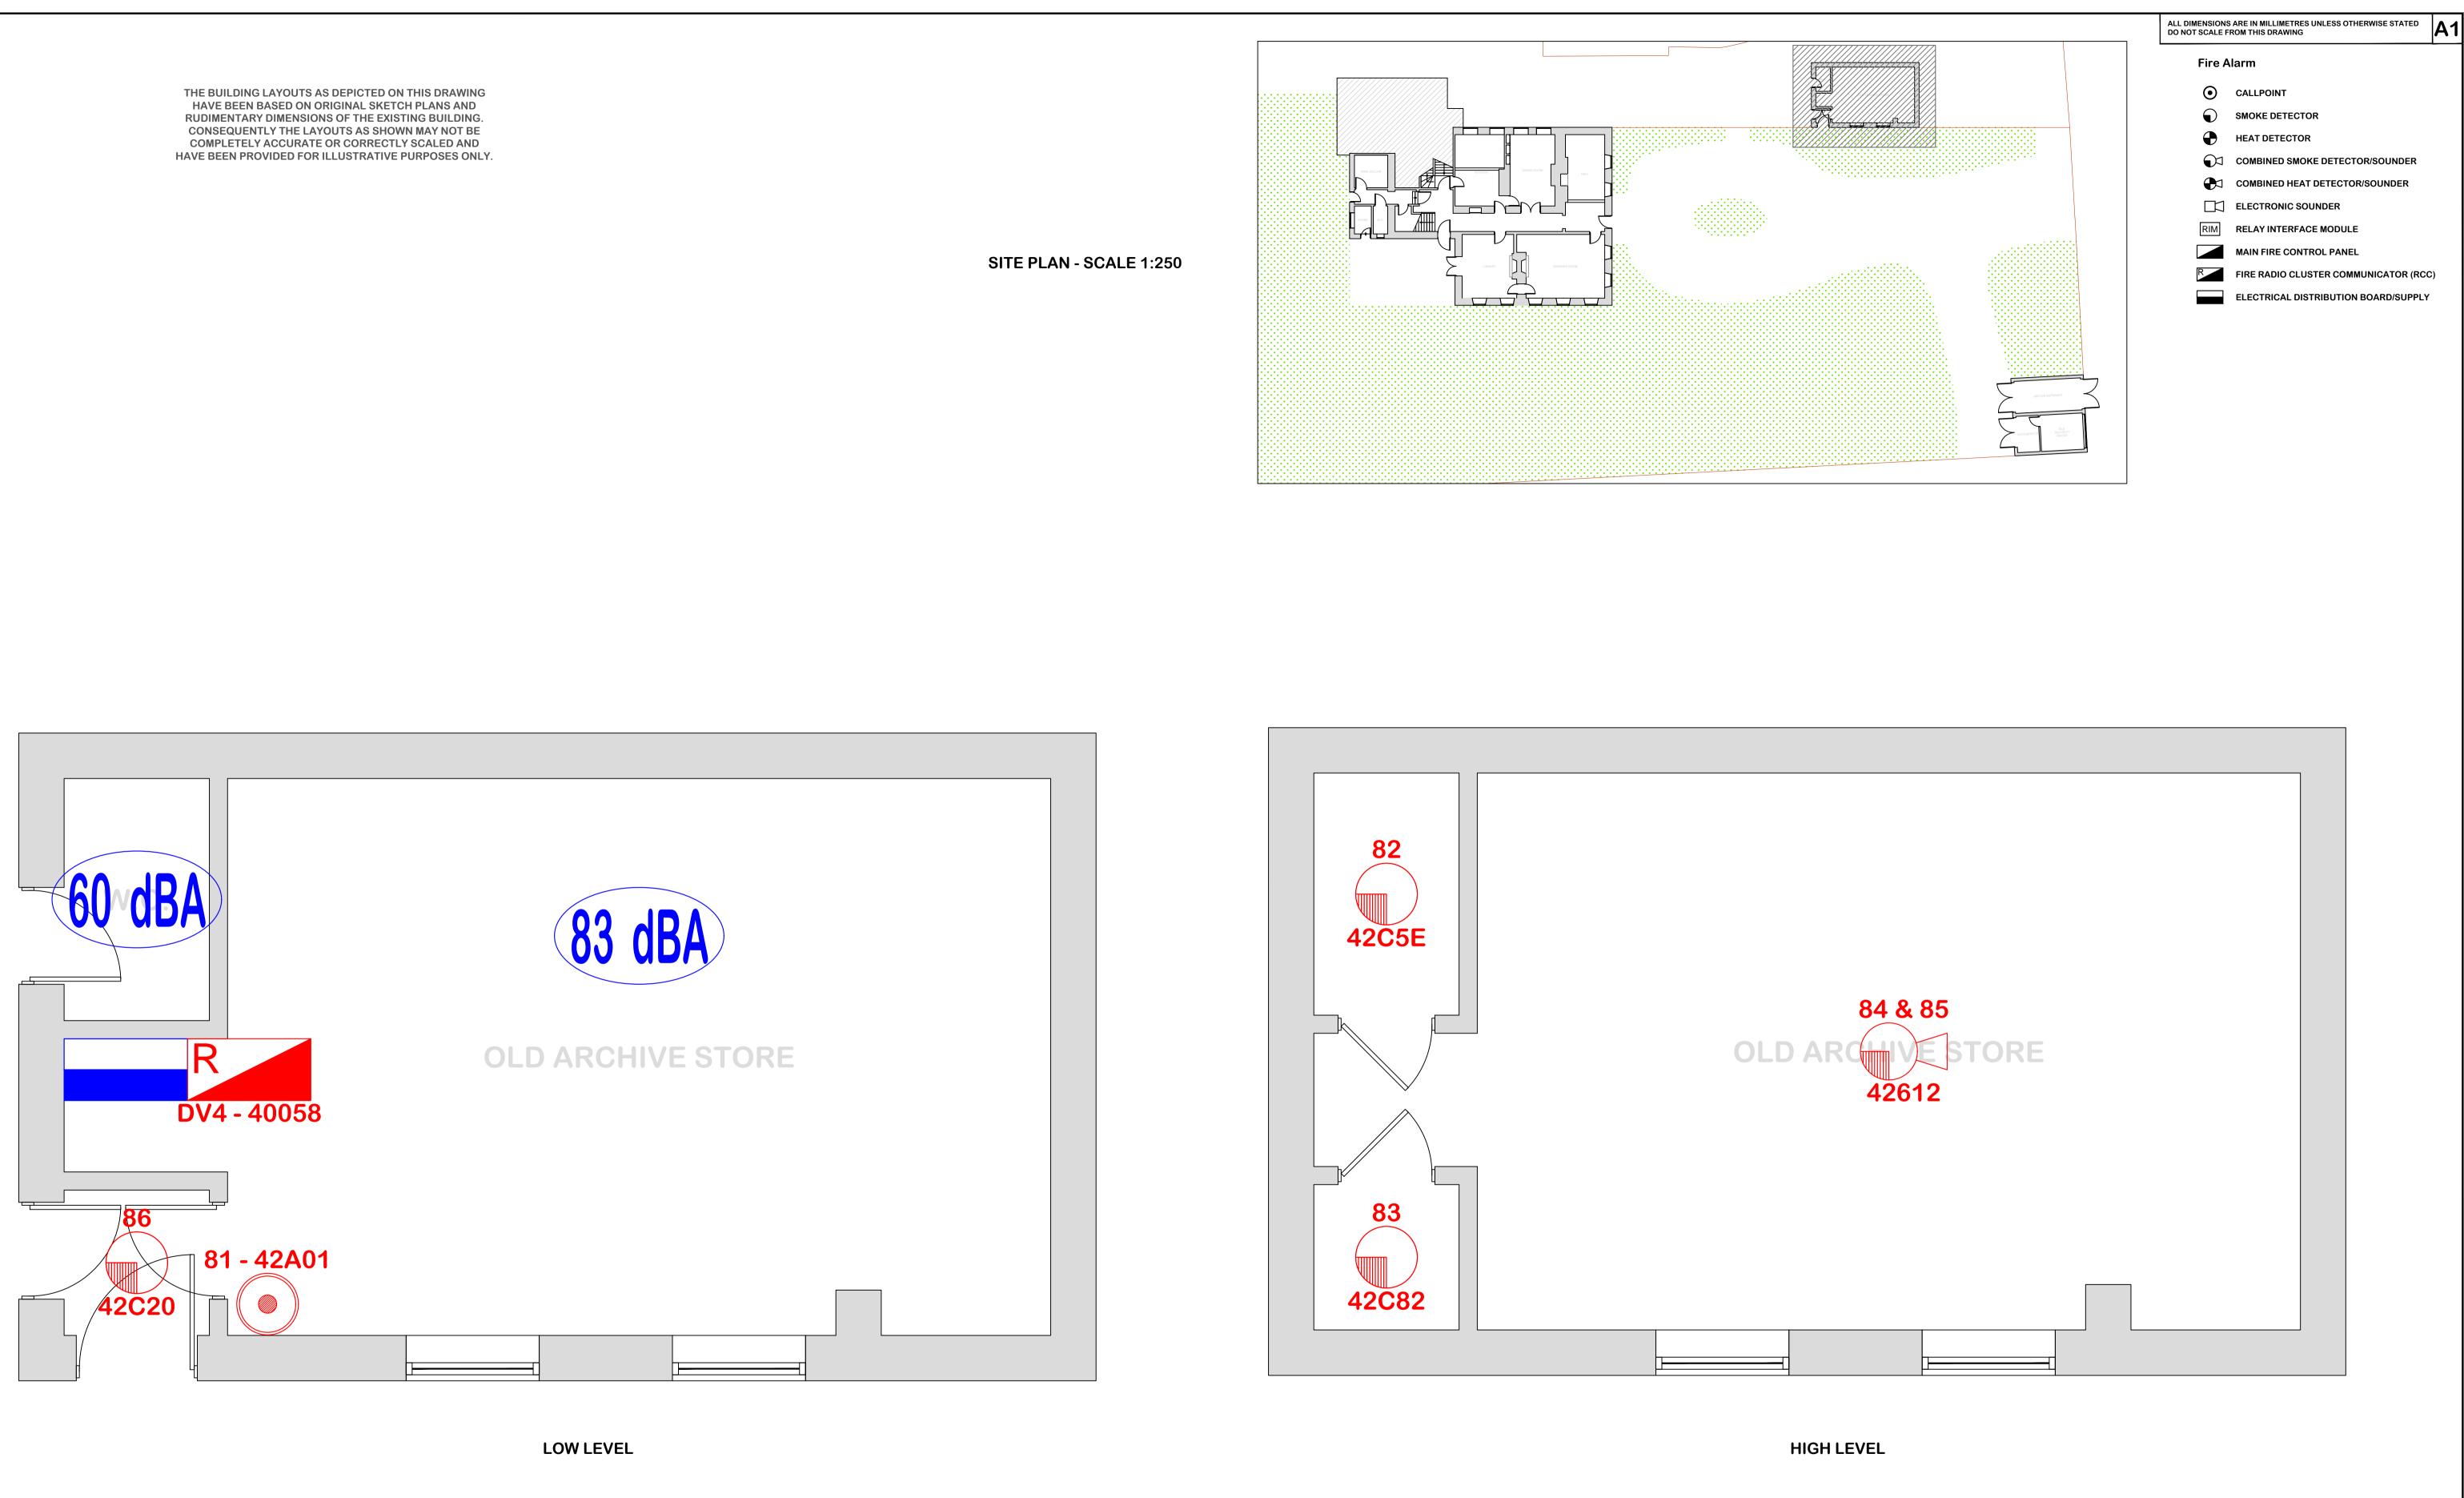

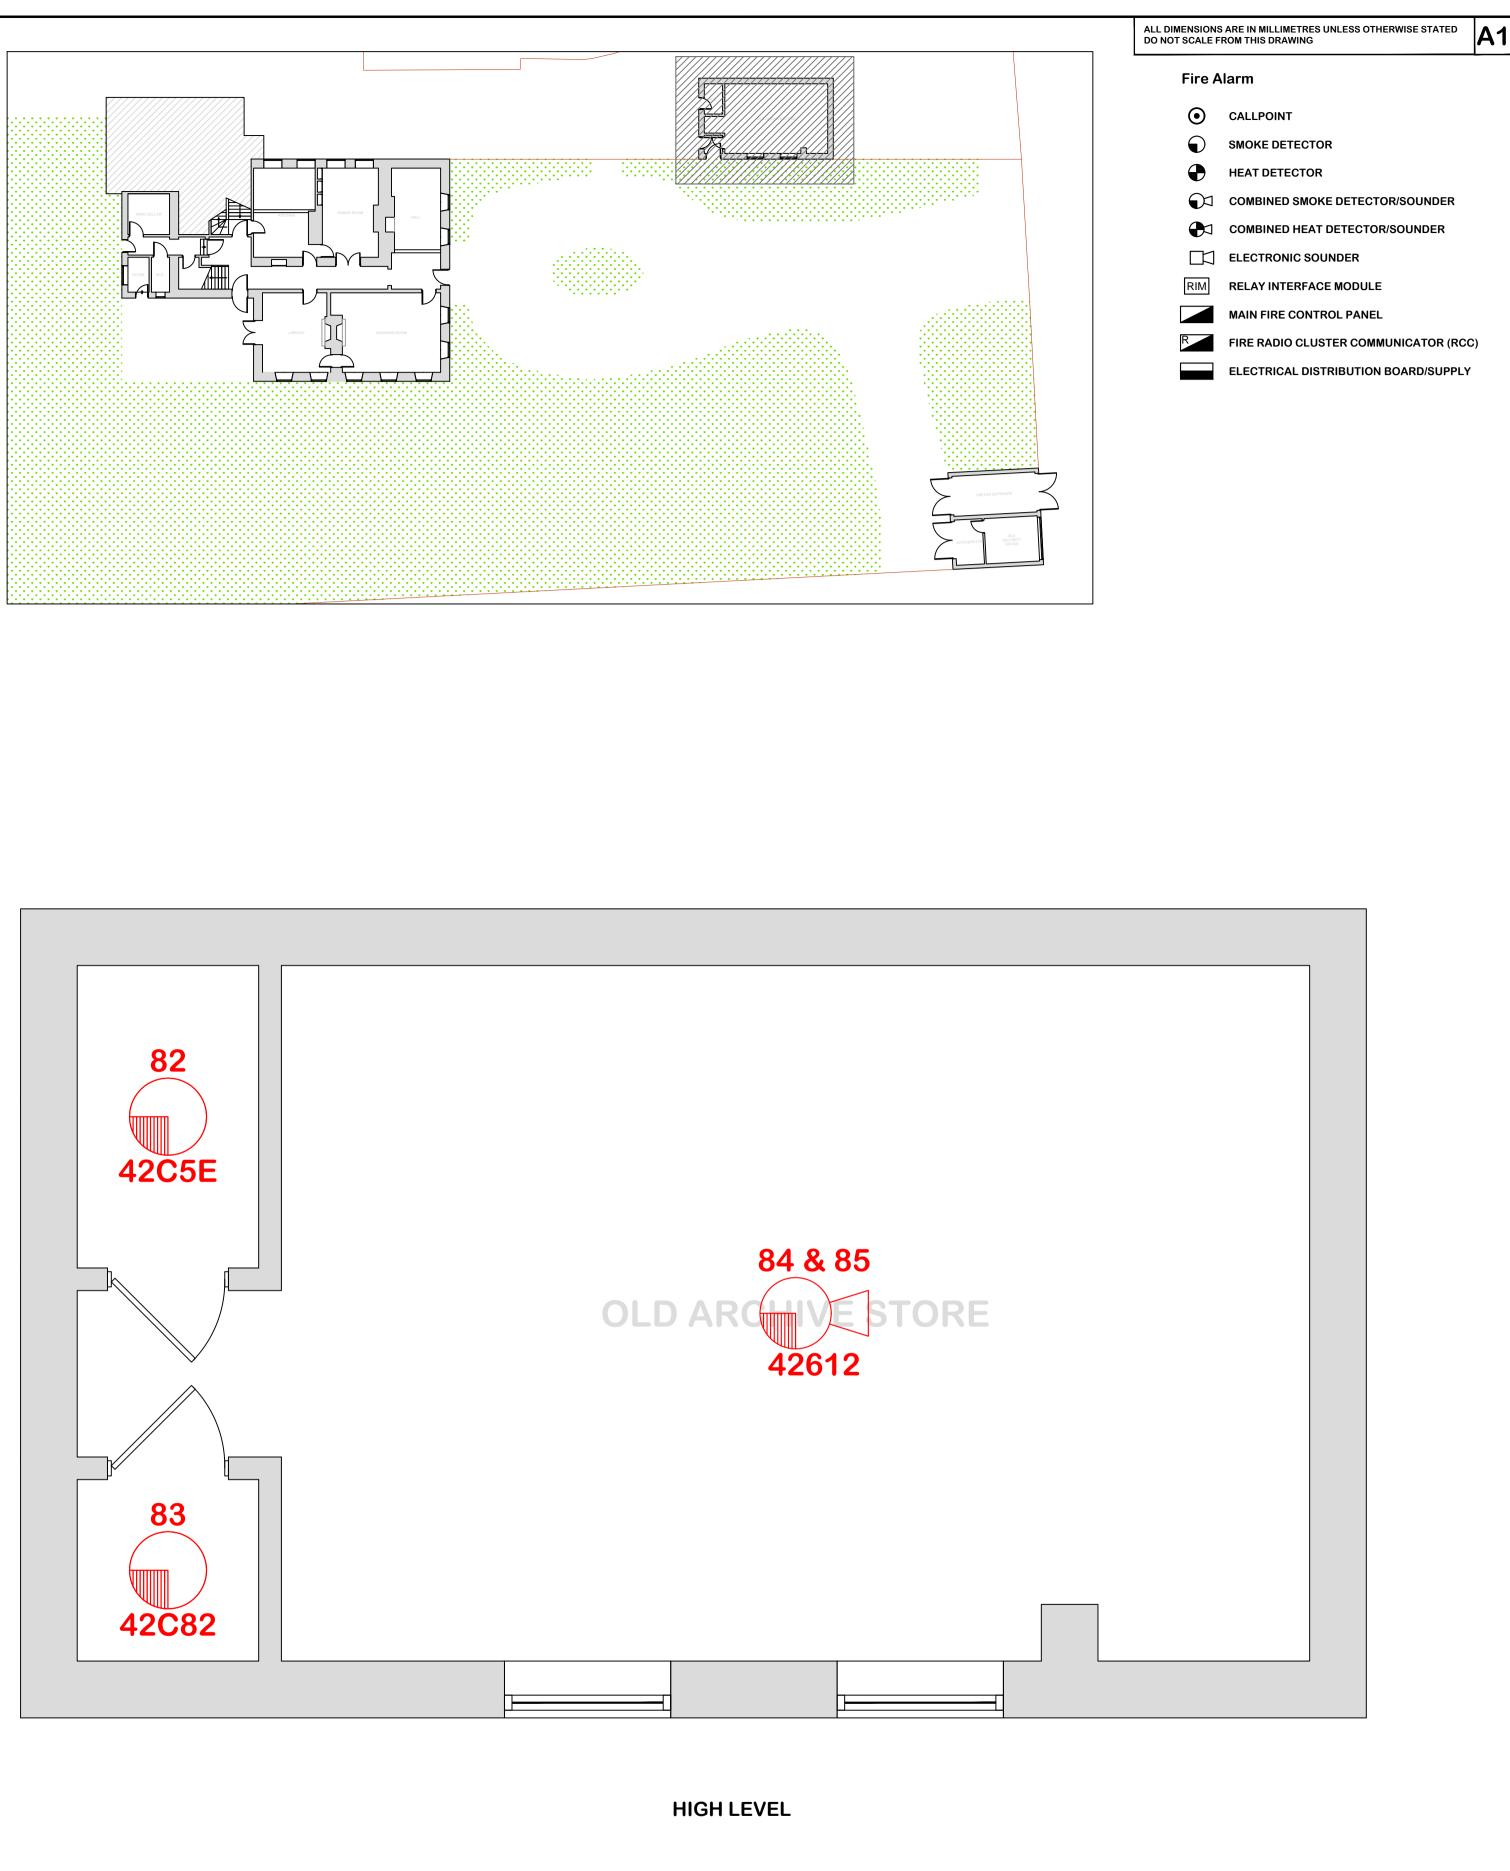

					Project:	Title:
.com					Salisbury Wiltshire	Proposed Fire Alarm System Replacement / Upgrade ARCHIVE STORE
	Revision	Description	Date	Checked		
	AMENDMENT RECORD					(RECORD DRAWING)

Drawn By: ISW	Date: DEC 15	© This drawing and/or design is the property of 'LIFE SAFETY SYSTEMS' and shall not be reproduced or copied in the whole or part in any way or conveyed to a third party without the owners written permission.					
Checked By:	Date:	Drawing Number:					
		SAMPLE/2015/05/FA120					
Scale @ A1:	Date:						
1:25 (APPROX)	DEC 15	Revision:					